



**DESIGNER'S NOTES**

1. THE SITE DRAWING PROVIDED IS FOR CONCEPT ONLY. THE DESIGN CONFORMS TO CURRENT COS CRITERIA, HOWEVER IT MAY NOT SUIT THE LOCAL SITE REQUIREMENT. THE CONTRACTOR SHALL BE RESPONSIBLE FOR COORDINATING AND FINALIZING THE SITE PLAN WITH THE INSTALLATION.

**PARKING REQUIREMENTS**

	MIN REQUIRED	SHOWN
TOTAL PARKING	104	105
HANDICAP PARKING	5	6



No.	Description	Date	Appr.


Date:	JULY 10
Scale:	
Drawing code:	

Designed by:	
Drawn by:	
Reviewed by:	
Submitted by:	

U. S. ARMY CORPS OF ENGINEERS  
ENGINEERING AND SUPPORT CENTER  
HUNTSVILLE, ALABAMA

CHILD DEVELOPMENT CENTER  
STANDARD DESIGN  
0 - 5 YEARS OF AGE, MEDIUM  
OVERALL SITE PLAN

Sheet reference number:  
**C-102**  
Sheet 2 of 4

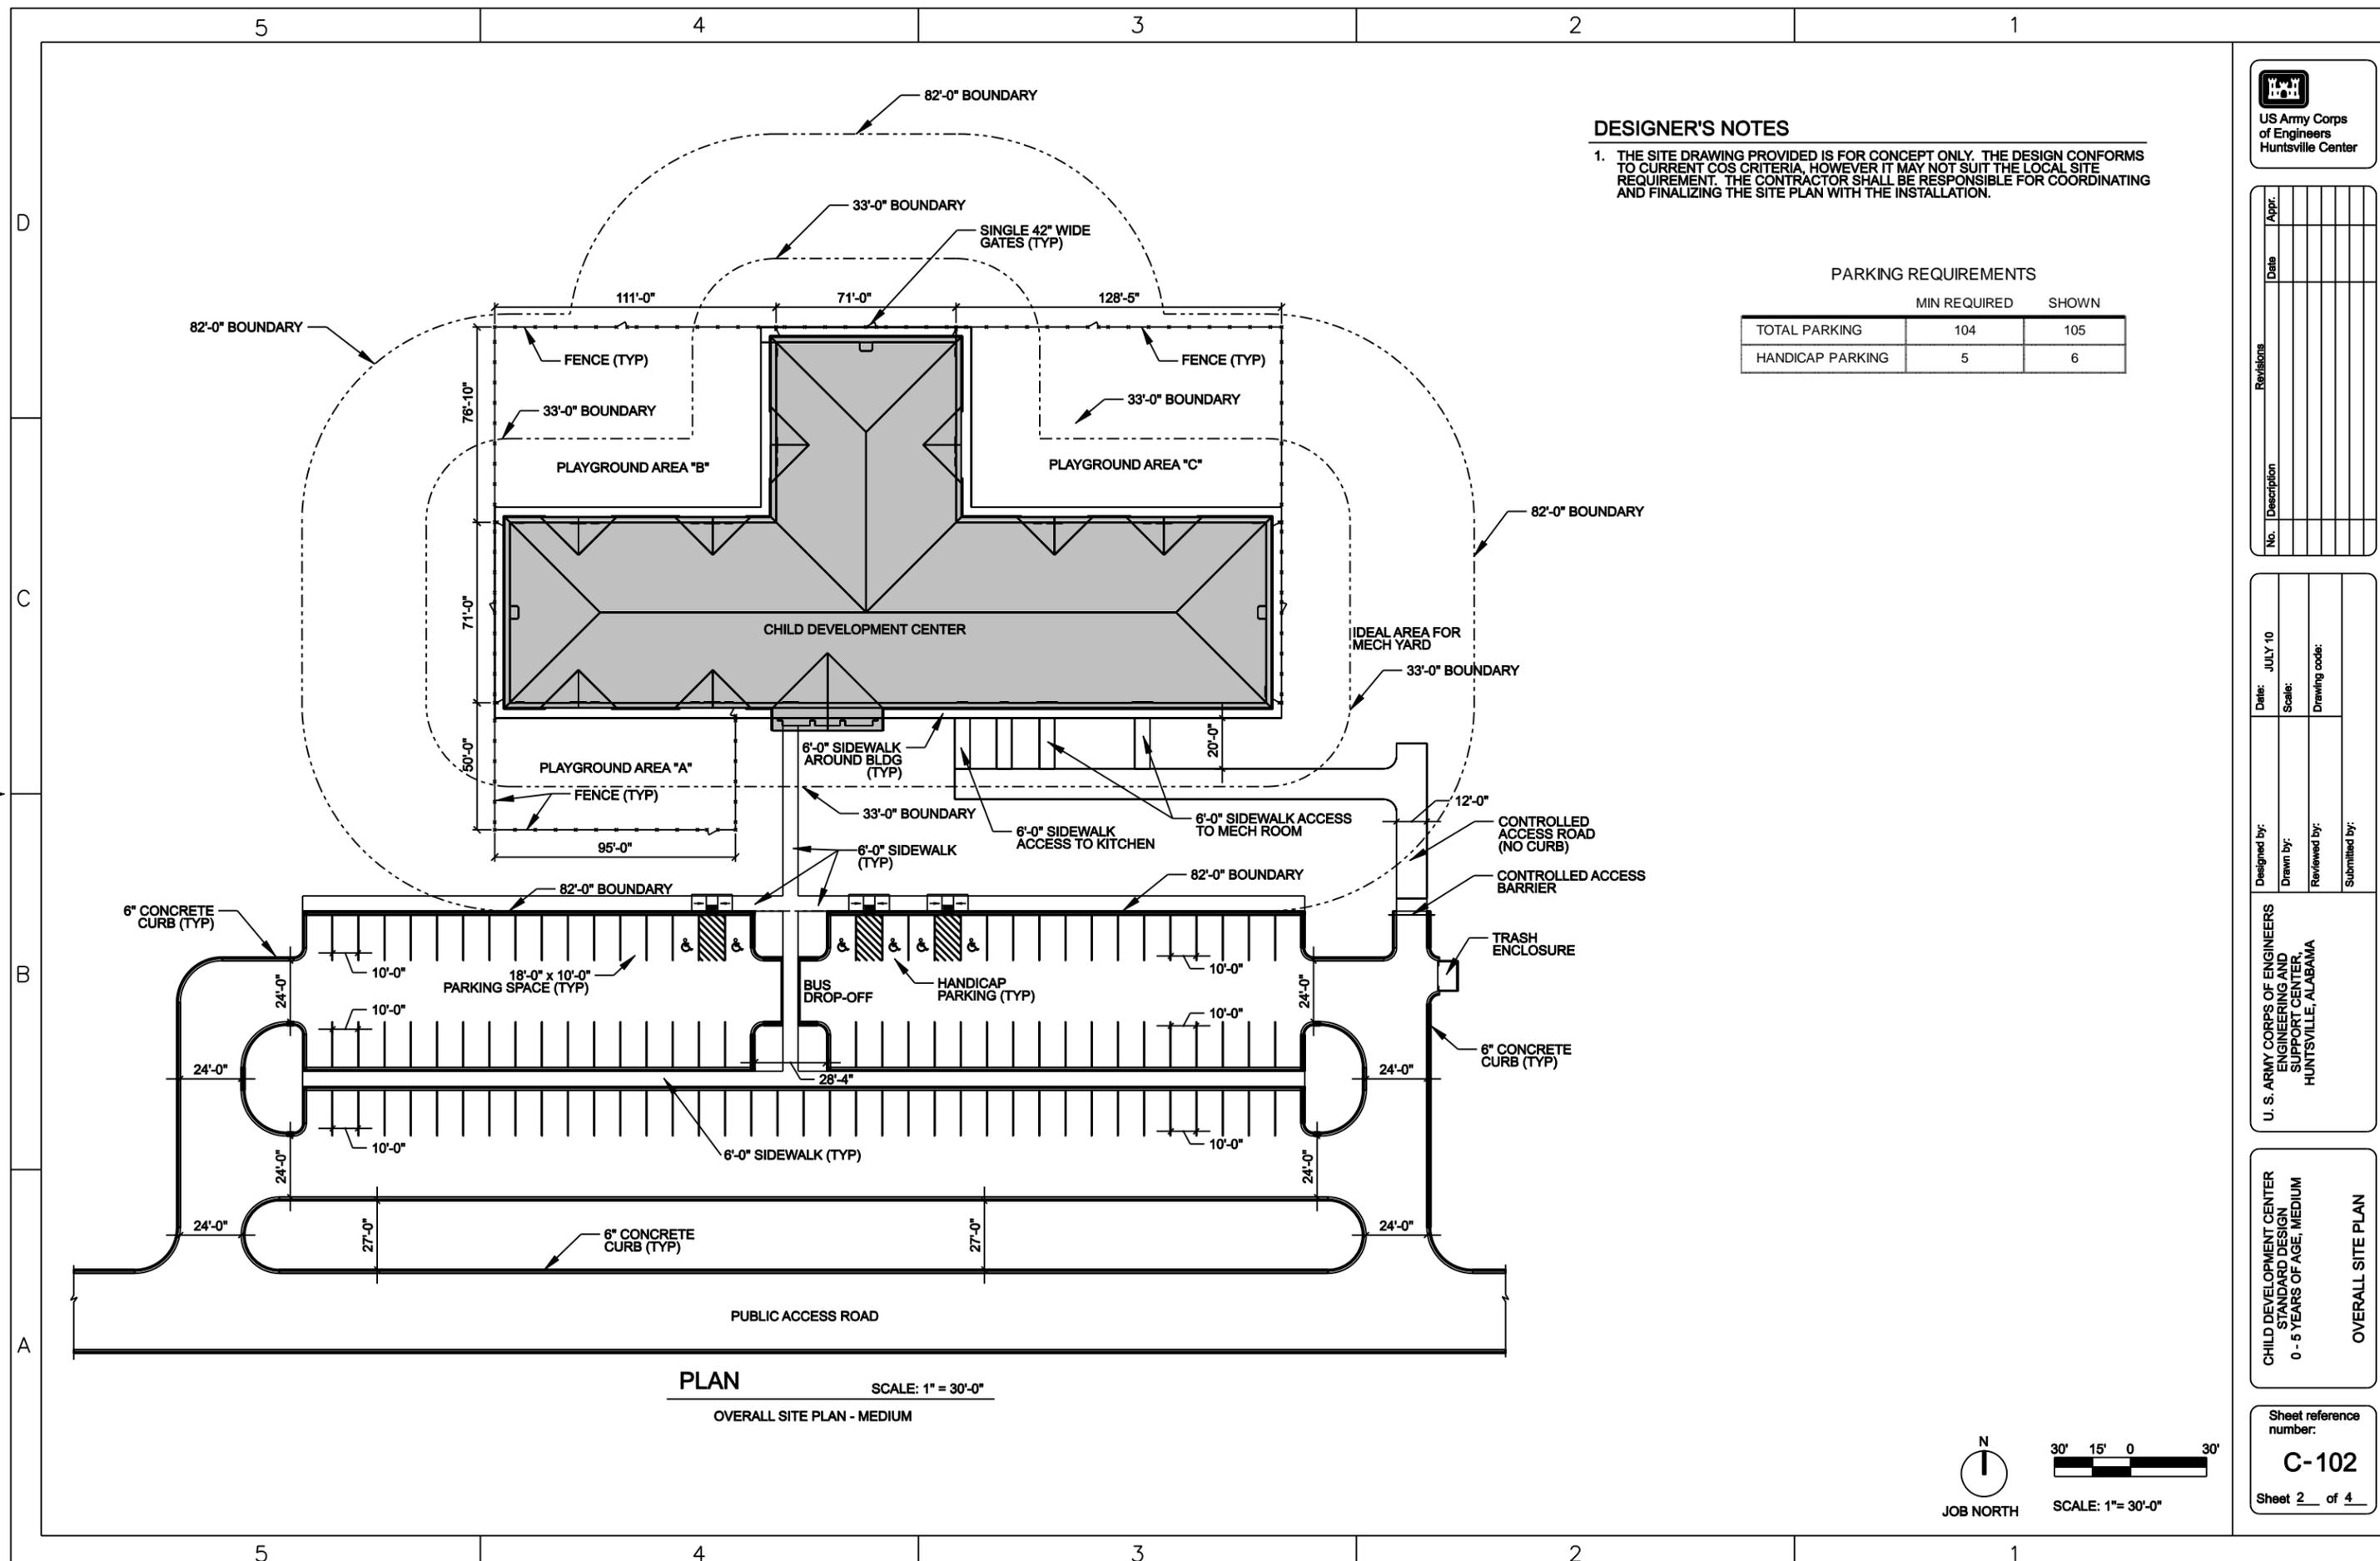

**PLAN**  
SCALE: 1" = 30'-0"  
OVERALL SITE PLAN - MEDIUM





LEGEND:


- ITEM NO. IN LIST OF EQUIPMENT  
EQUIPMENT NUMBER
- ITEM NO. IN LIST OF MATERIAL
- INTERIOR FIXED CAMERA W/ ID NO.
- EXTERIOR FIXED CAMERA W/ ID NO.
- SURVEILLANCE EQUIPMENT RACK
- PARENTAL VIEWING MONITOR
- PVM WORKSTATION
- ADMINISTRATORS WORKSTATION
- POWER PANEL
- (E) EXISTING

DESIGNER'S NOTES

1. REFER TO THE ROOM-BY-ROOM DESCRIPTION FOR ADDITIONAL SECURITY AND MONITORING REQUIREMENTS.
2. ASSUMPTIONS (FOR CAMERA PLACEMENT ON DRAWINGS):  
ALL CEILINGS ARE EIGHT (8) FEET SUSPENDED TILES UNLESS OTHERWISE NOTED.  
ALL FURNITURE AND LANDSCAPE PLACEMENT WILL NOT BLOCK CAMERA VIEWS.  
BUILDINGS WILL HAVE "OVERHANGS / SOFFITS" TO ACCOMMODATE EXTERIOR CAMERAS.  
EXTERIOR CAMERAS ARE PLACED BASED ON EXPECTED LOCATION OF PLAYGROUNDS.

KEY NOTES

1. ALL INTERIOR CAMERAS SHALL HAVE A LENS SIZE OF 2.9-8.2MM UNLESS OTHERWISE NOTED.
2. ALL EXTERIOR CAMERAS SHALL HAVE A LENS SIZE OF 2.9-8.2MM UNLESS OTHERWISE NOTED.
3. EXTERIOR CAMERAS ARE TO BE INSTALLED IN ACTIVE PLAY ROOMS. CAMERAS SHALL HAVE A LENS SIZE OF 2.9-8.2MM UNLESS OTHERWISE NOTED.
4. CCTV RACK MOUNT POWER SUPPLIES (SEE NOTE 1A ON SHEET X-001)
5. SURVEILLANCE EQUIPMENT RACK (SER) LOCATION (SEE NOTE 1B ON SHEET X-001).
6. PVM WORKSTATION (SEE NOTE 1D & 11 ON SHEET X-001).
7. RJ-45 LAN JACK LOCATION (SEE NOTE 10 ON SHEET X-001).
8. PARENTAL VIEWING MONITOR (PVM) LOCATION (SEE NOTE 1C & 11 ON SHEET X-001).

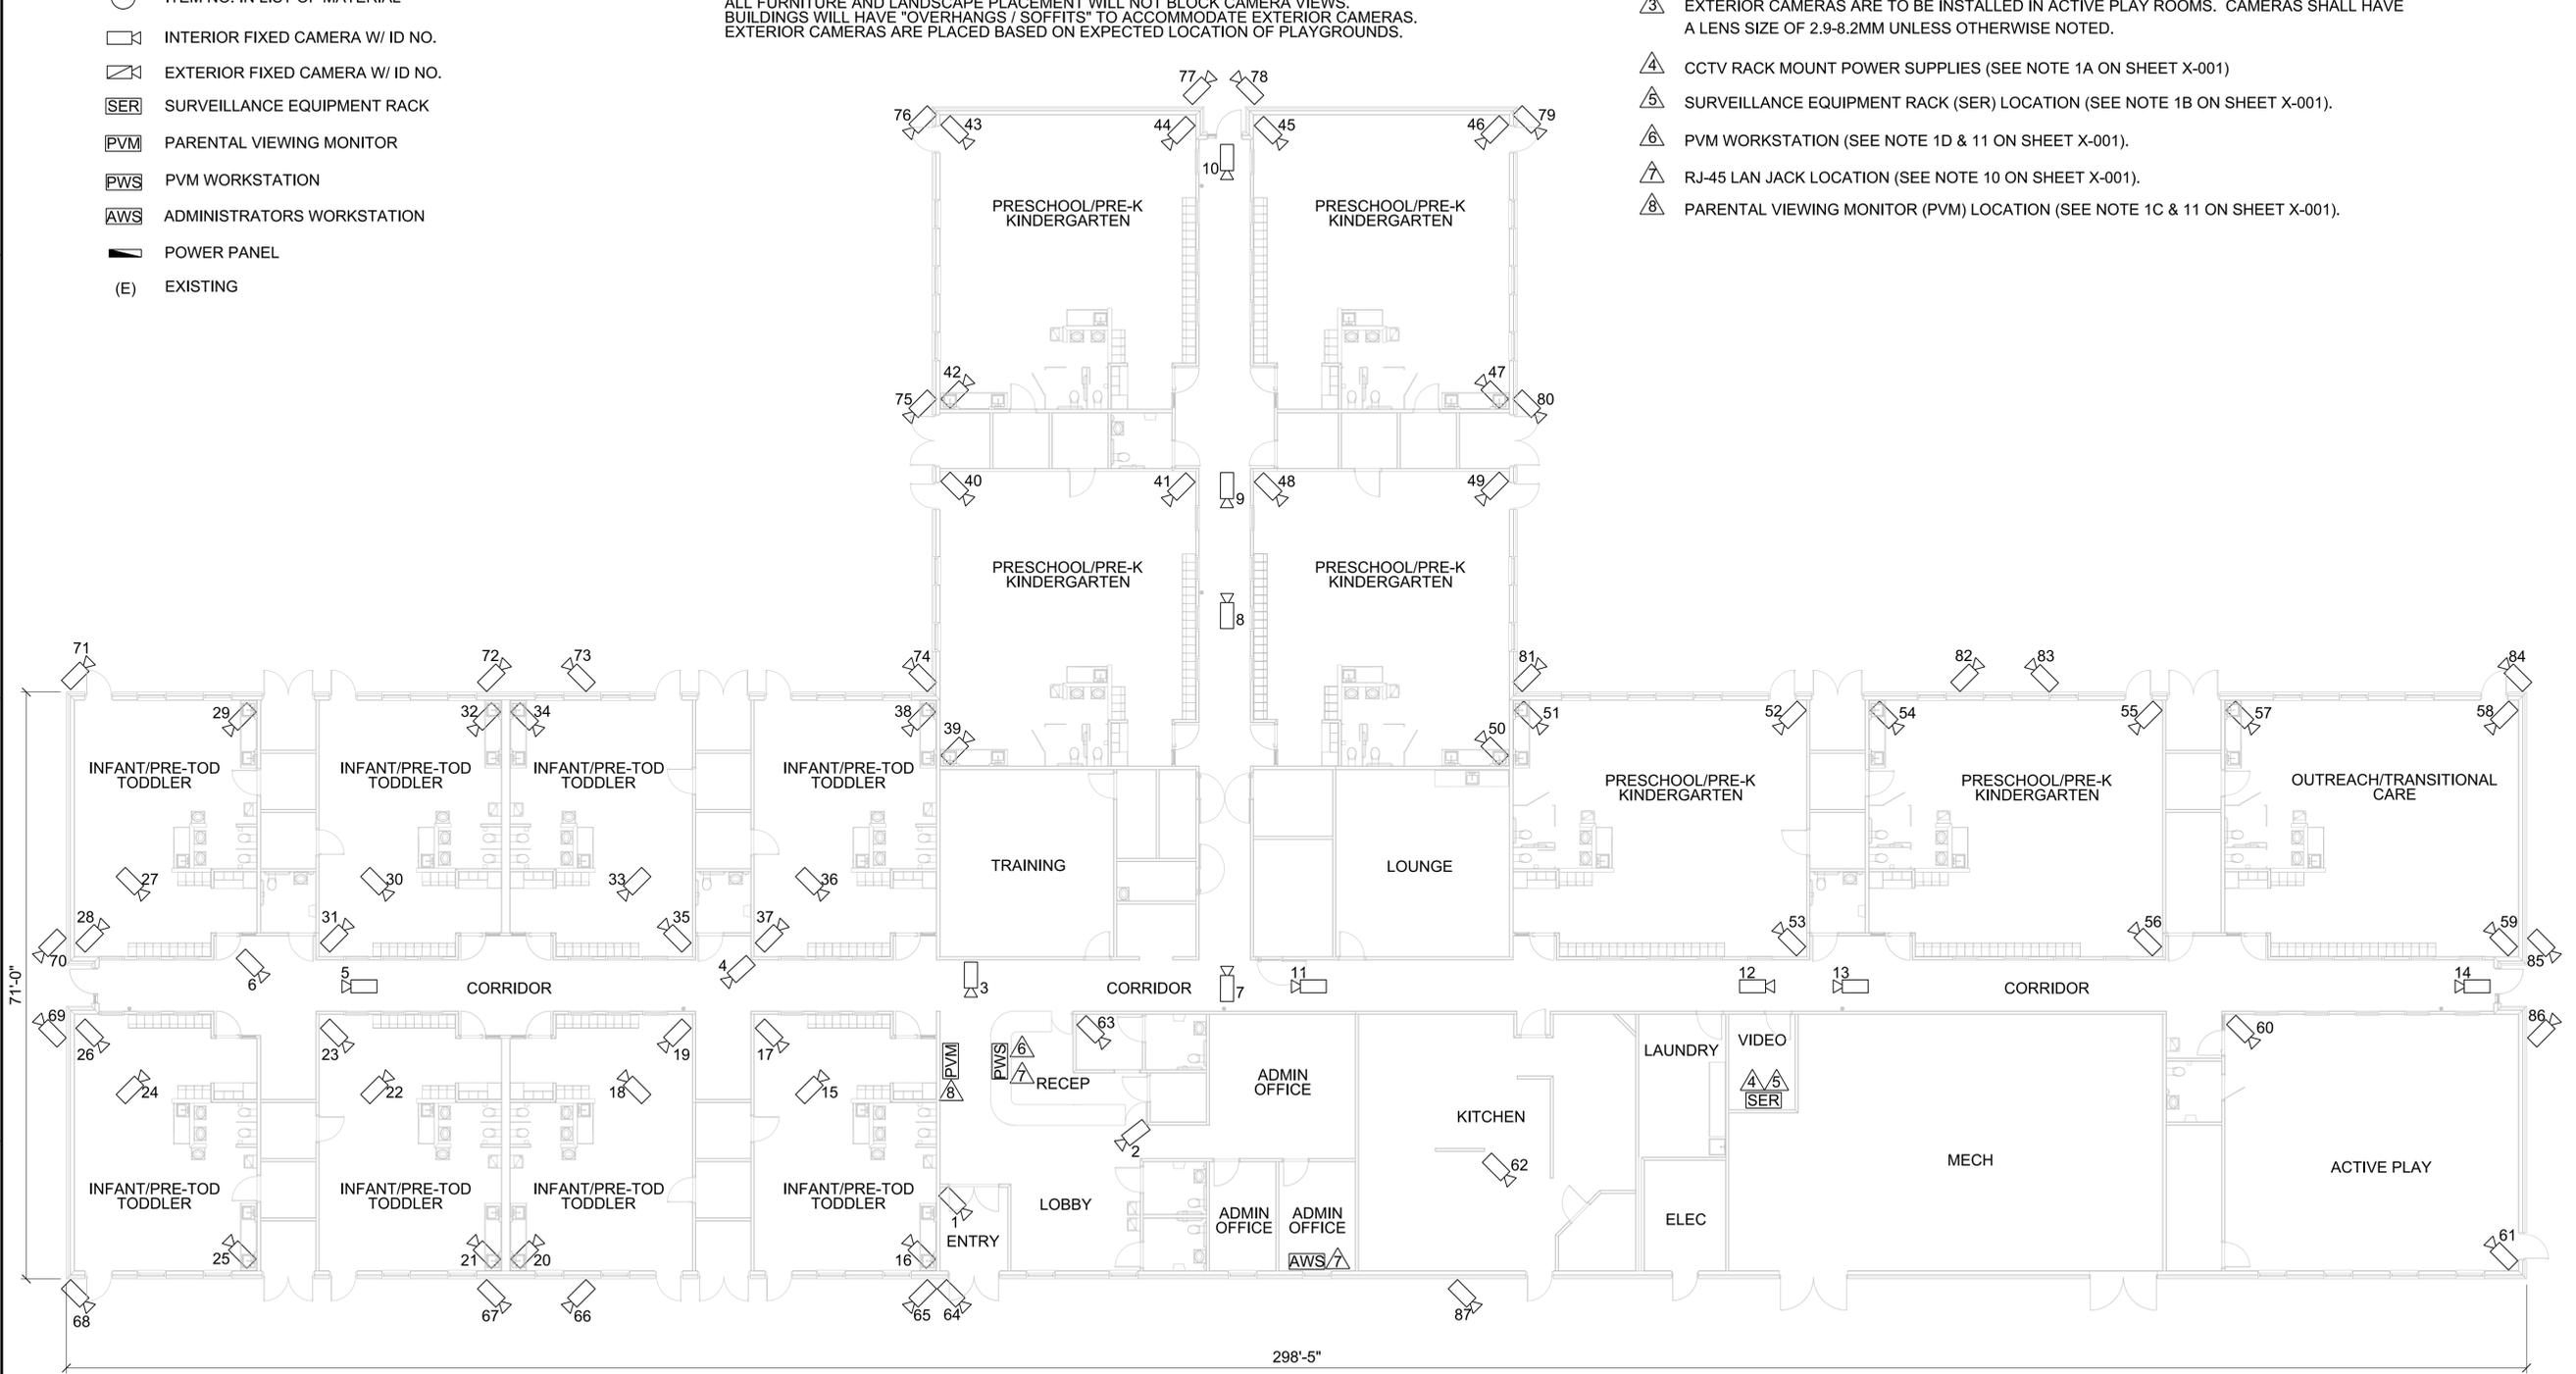

PLAN  
SCALE: NTS  
SECURITY & MONITORING PLAN - MEDIUM



No.	Description	Date	Appr.

Designed by:	Date:	JULY 10
Drawn by:	Scale:	
Reviewed by:	Drawing code:	
Submitted by:		

U. S. ARMY CORPS OF ENGINEERS  
ENGINEERING AND  
SUPPORT CENTER  
HUNTSVILLE, ALABAMA

CHILD DEVELOPMENT CENTER  
STANDARD DESIGN  
0 - 5 YEARS OF AGE, MEDIUM  
SECURITY &  
MONITORING PLAN

Sheet reference  
number:  
**X-102**  
Sheet 4 of 4