


Symbol	Description	Date	Author

Designed by: CE HMC-ED-SC-A	Design file no. ARCH. BRD. DURENAY	Date: 08 JAN 2009	Rev. DT 01
Drawn by: CE HMC-ED-SC-A	Drawing code: CE HMC-ED-SC-A	File name: Post date: 30 JAN 2009	Plot scale: 1"=1'-0"
U. S. ARMY ENGINEERING AND SUPPORT CENTER, HUNTSVILLE HUNTSVILLE, ALABAMA	U. S. ARMY ENGINEERING AND SUPPORT CENTER, HUNTSVILLE HUNTSVILLE, ALABAMA	U. S. ARMY ENGINEERING AND SUPPORT CENTER, HUNTSVILLE HUNTSVILLE, ALABAMA	U. S. ARMY ENGINEERING AND SUPPORT CENTER, HUNTSVILLE HUNTSVILLE, ALABAMA

DA FACILITIES STANDARDIZATION PROGRAM
 ARMY FIRE STATION DESIGN GUIDE
 FOR HEADQUARTERS FIRE STATION

Sheet reference number:
A8-HQ
 Sheet 8 of 14

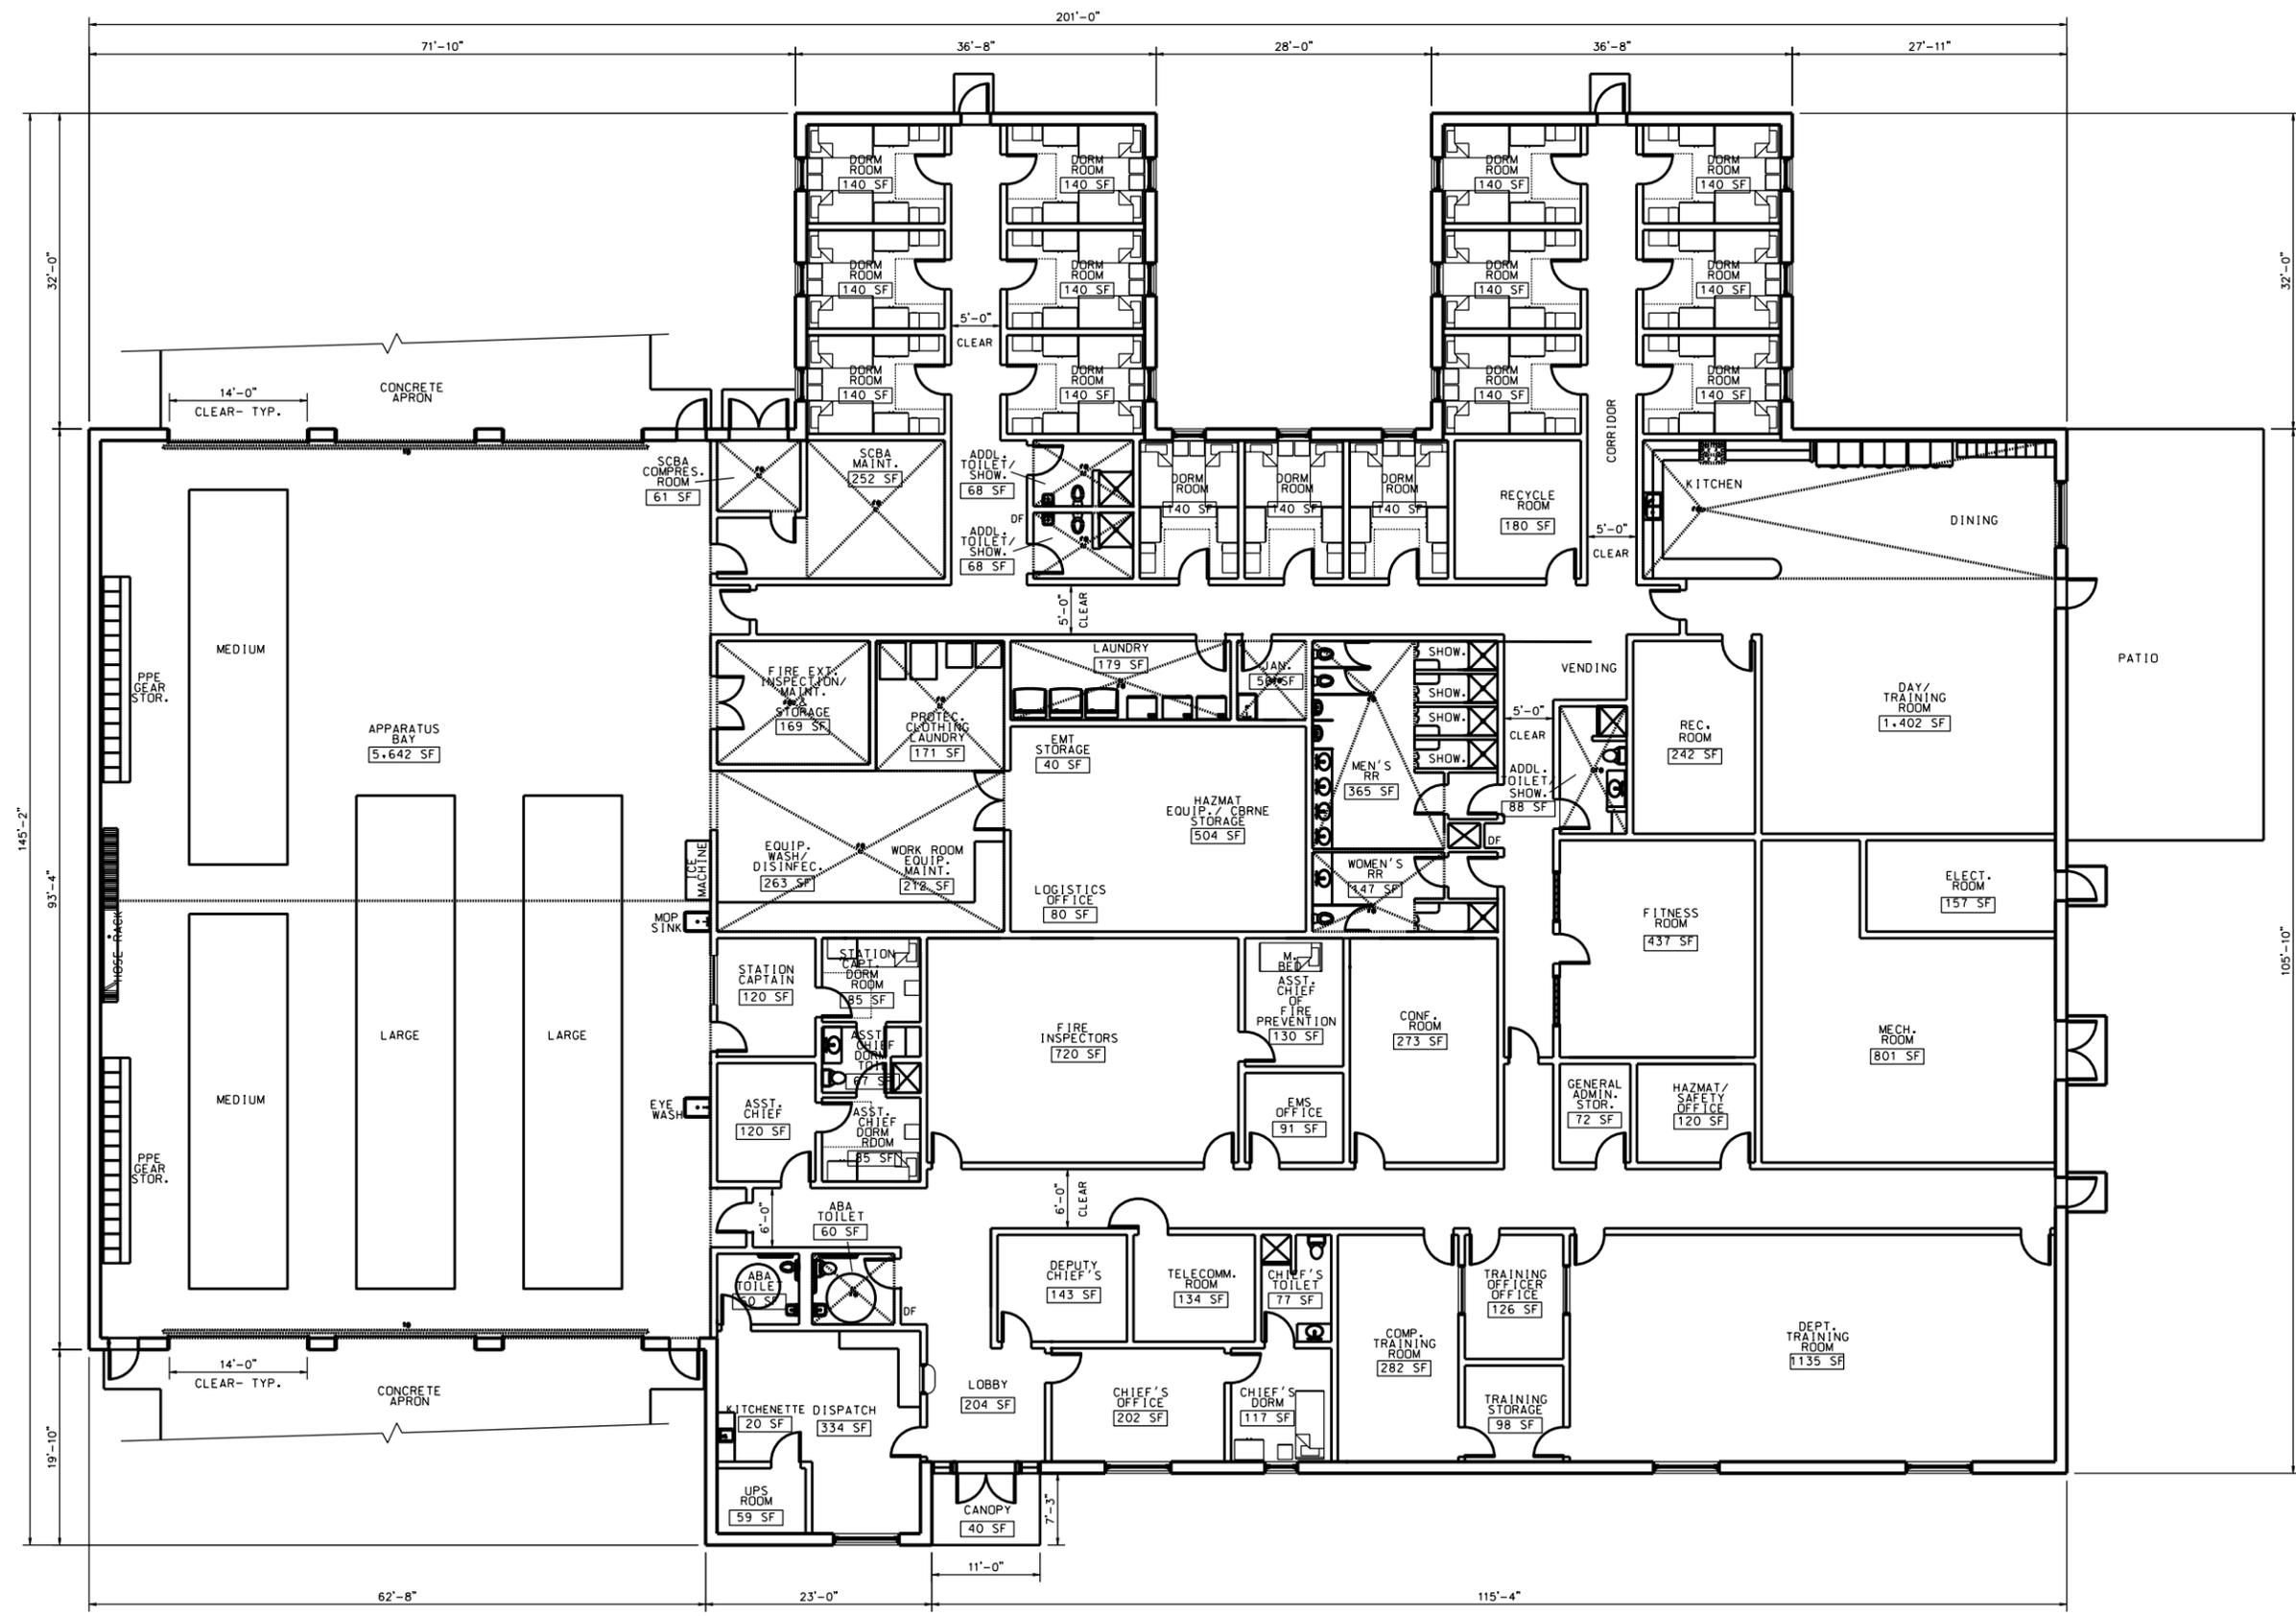

1 FLOOR PLAN
 THREE COMPANY HEADQUARTERS FIRE STATION
 SCALE: 1' - 0" = 1/8" 23,052 SQ.FT.

FIRST FLOOR= 23,012 SF
 CANOPY= 40 SF
 GROSS TOTAL= 23,052 SF

