 


1 FIRST FLOOR PLAN- TWO STORY
 THREE COMPANY HEADQUARTERS FIRE STATION
 SCALE: 1'-0"=1/8" 27,578 SF

FIRST FLOOR= 18,689 SF
 SECOND FLOOR= 8,849 SF
 CANOPY= 40 SF
 GROSS TOTAL= 27,578 SF




| Symbol | Description | Date | Approved |
|--------|-------------|------|----------|
| | | | |
| | | | |
| | | |
|----------------------------------|--------------------------------------|------------------------|
| Designed by: CE HMC-ED-SC-A | Date: 06 Jan 2009 | Rev: 07 |
| Drawn by: ARCH. BRCH-DUVERNEY | Design file no.: | |
| Reviewed by: CE HMC-ED-SC-A | Drawing code: | |
| Submitted by: CE HMC-ED-SC-A | File name: Plot title: 1'-0"=1/8" | Plot scale: 1'-0"=1/8" |

DA FACILITIES STANDARDIZATION PROGRAM
 ARMY FIRE STATION DESIGN GUIDE
 FOR
 HEADQUARTERS FIRE STATION

Sheet reference number:
A13-HQ
 Sheet 13 of 14

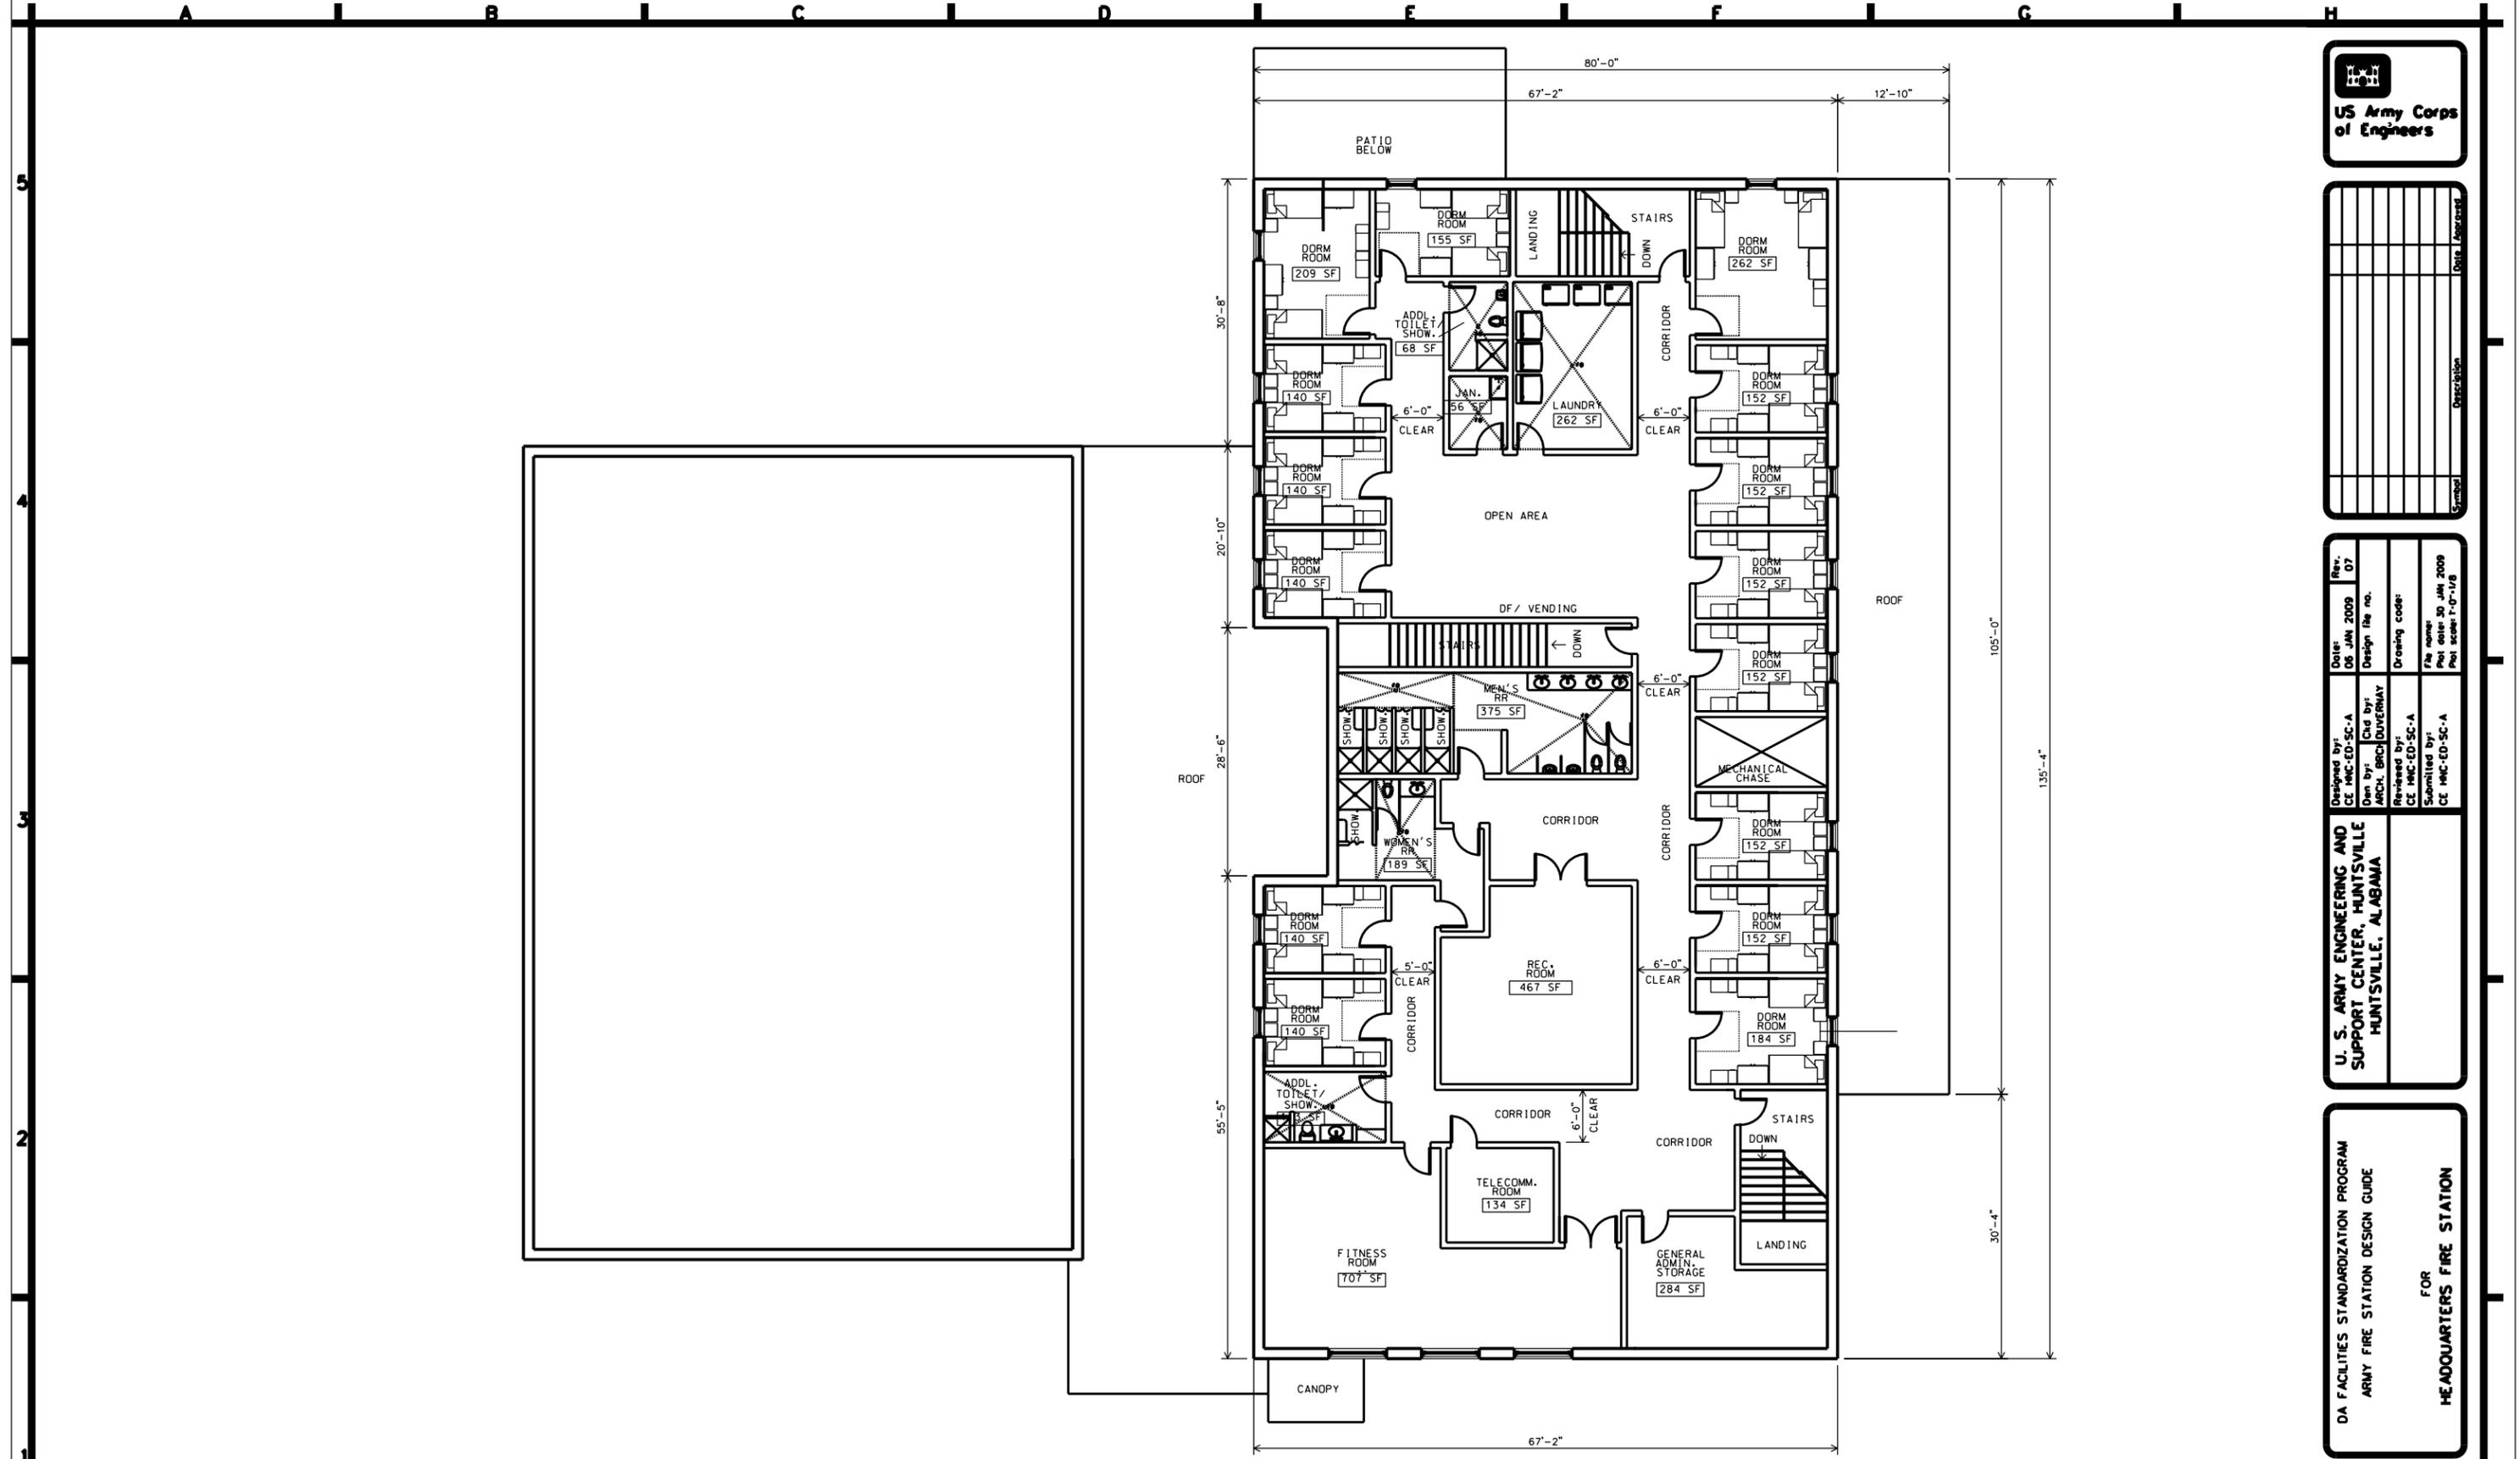

2
A6-HQ

SECOND FLOOR PLAN- TWO STORY
THREE COMPANY HEADQUARTERS FIRE STATION
SCALE: 1' - 0" = 1/8" 27,578 SF

FIRST FLOOR= 18,689 SF
SECOND FLOOR= 8,849 SF
CANOPY= 40 SF
GROSS TOTAL= 27,578 SF



| Date | Description | Drawn |
|------|-------------|-------|
| | | |
| | | |
| Rev. | Date | By | Description |
|------|-------------|----------------|-------------|
| 07 | 08 JAN 2009 | CE MAC-ED-SC-A | Design |
| | | | |
| | | | |
U. S. ARMY ENGINEERING AND
SUPPORT CENTER, HUNTSVILLE
HUNTSVILLE, ALABAMA

DA FACILITIES STANDARDIZATION PROGRAM
ARMY FIRE STATION DESIGN GUIDE
FOR
HEADQUARTERS FIRE STATION

Sheet
reference
number:
A14-HQ
Sheet 14 of 17